





**ROUGH-IN PLAN** 

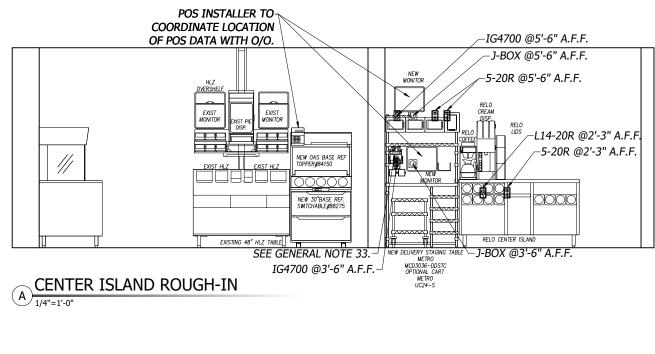


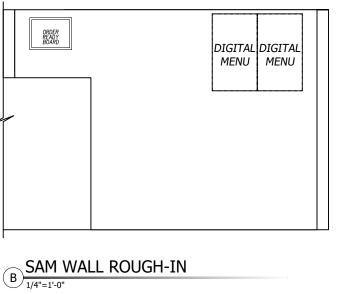

B SAM WALL ELEVATION 1/4"=1'-0"

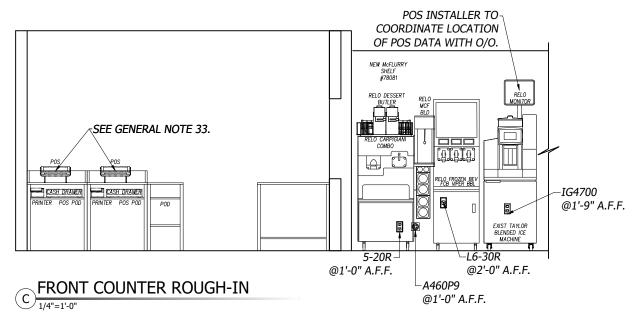

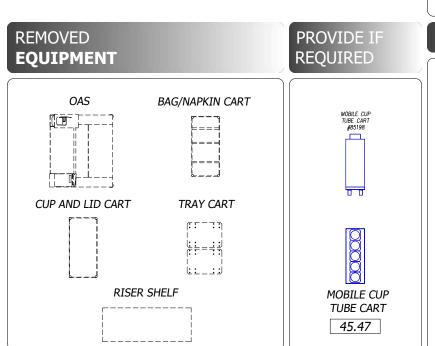

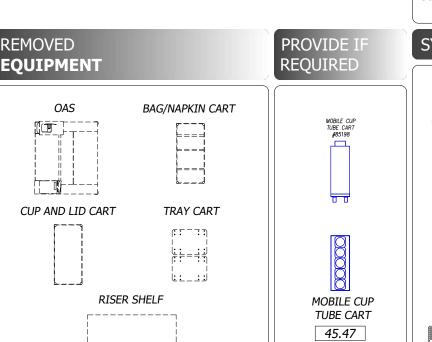



GENERAL **NOTES** 

- 1) USE EXISTING ROOF OPENINGS UNLESS OTHERWISE NOTED ON SCOPE OF WORK. IF NEW EXHAUST FAN ROOF OPENING IS REQUIRED, GC TO VERIFY PROPOSED ROOF OPENING LOCATION IS LOCATED A MIN. OF 10'-0" FROM HVAC AIR INTAKE. GC TO CUT NEW ROOF OPENING AND INSTALL NEW CURB AND FAN. H&K INSTALLER TO INSTALL NEW DUCT. GC TO WRAP DUCT OR CONSTRUCT ENCLOSURE IF REQUIRED BY LOCAL CODES. EC TO WIRE EXHAUST FAN TO ANSUL INTERLOCK SYSTEM.
- 2) KITCHEN INSTALLER TO MOUNT RACEWAY BELOW HOOD. EC TO MAKE FINAL CONNECTIONS FROM RACEWAY TO TERMINAL BLOCK INSIDE CHASE. IF GAS, KITCHEN INSTALLER TO WALL MOUNT GAS MANIFOLD BELOW HOOD. PC TO INSTALL QUICK DISCONNECT LINES AND MAKE FINAL CONNECTIONS TO IN-BOUND GAS LINE FROM CHASE AND TO INDIVIDUAL APPLIANCES.
- 3) ALL UTILITIES FOR APPLIANCES BELOW HOOD TO RUN OVERHEAD AND DOWN MECHANICAL CHASE. EC TO MAKE FINAL CONNECTIONS TO TERMINAL BLOCK INSIDE CHASE. IF GAS, PC TO MAKE FINAL CONNECTIONS AT GAS MANIFOLD.
- 4) IF CHASE IS RELOCATED, GC TO COORDINATE MODIFICATION OF ANSUL SYSTEM WITH ANSUL. RELOCATE OR PROVIDE NEW UTILITIES AS NEEDED.
- 5) GC TO VERIFY ALL EXISTING UTILITIES AND STRUCTURAL FLOOR LOADING CONDITIONS. REMOVE, CLOSE, SEAL, CAP AND/OR RELOCATE EXISTING LINES, DRAINS & UTILITIES. RUN DRAIN LINES TO EXISTING FLOOR DRAINS IF POSSIBLE, OR RELOCATE/INSTALL NEW FLOOR DRAINS, GAS LINES, AND SLEEVES AS NEEDED. THE GC SHALL COORDINATE ALL FINAL CONNECTIONS TO EQUIPMENT WHERE APPLICABLE.
- 6) GC TO REMOVE, CLOSE, SEAL, CAP, RELOCATE, OR INSTALL NEW LINES, DRAINS, RECEPTACLES, CORDS, UTILITIES, ROOF OPENINGS AS NEEDED FOR NEW AND RELOCATED EQUIPMENT. GC TO PATCH, SEAL AND/OR FINISH WALL, FLOOR, CEILING AND/OR ROOF AS NECESSARY TO MATCH EXISTING.
- 7) GC AND INSTALLER TO VERIFY LOCATION OF EXISTING EQUIPMENT TO REMAIN IN RELATION TO NEW AND RELOCATED EQUIPMENT.
- 8) REMOVE AND REPLACE DAMAGED QUARRY TILE FLOORING ADJACENT TO THE PROJECT AREA(S). MATCH EXISTING QUARRY TILE WHERE PATCHING DAMAGED TILE OR WHERE EXTENDING THE TILE FIELD IN NEW
- 9) IN THE EVENT REMOVAL OR RELOCATION OF EQUIPMENT RESULTS IN EXPOSING EXISTING KITCHEN FLOOR TILE THAT IS NOT ABRASIVE, GC SHALL REPLACE ALL EXISTING SMOOTH KITCHEN QUARRY TILE WITH ABRASIVE QUARRY TILE. SUCH REPLACEMENT TILE SHALL BE LOCATED, AT A MINIMUM, IN FRONT OF ALL GRILLS, FRYERS, BAGGING STATIONS, SINKS OR ANY LOCATION WHERE GREASE OR WATER CAN ACCUMULATE ON THE FLOOR CAUSING A SLIP AND FALL HAZARD. THE TILE SHALL EXTEND A MINIMUM OF ONE TILE COURSE UNDER THE EDGE OF THE FIXTURE OR EQUIPMENT AND EXTEND THE ENTIRE LENGTH OF THE FIXTURE OR EQUIPMENT.
- 10) INSTALLER TO INSTALL NEW AND RELOCATED EQUIPMENT, GC TO MAKE FINAL CONNECTIONS.
- 11) ALL INTERIOR FINISHES SHALL BE COORDINATED WITH DECOR & SEATING DRAWINGS BY OTHERS.
- 12) GC TO OBTAIN ALL PERMITS REQUIRED PER LOCAL CODE.
- 13) ALL WORK SHALL COMPLY WITH ALL APPLICABLE STATE AND LOCAL HEALTH, SAFETY AND CONSTRUCTION CODES. G.C., E.C., P.C. TO VERIFY THAT ALL KITCHEN EQUIPMENT, SAFETY AND INTERLOCK UTILITIES ARE FUNCTIONAL AND IN CONFORMANCE WITH ALL LOCAL CODES PRIOR TO COMPLETION OF REMODEL. G.C. TO COORDINATE ANY CORRECTIONS OF ANY DEFICIENCIES WITH McDONALD'S CONSTRUCTION, SUBCONTRACTORS, AND/OR OWNER/OPERATOR.
- 14) ALL ELECTRICAL MATERIAL USED ON THIS PROJECT SHALL BE "UL" LISTED AND LABELED.
- 15) ALL DIMENSIONS SHOWN ARE TAKEN FROM FACE OF WALL FINISH. THE GC/ALL TRADES SHALL MAKE NECESSARY DIMENSIONAL ALLOWANCES.
- 16) ALL J-BOXES, DCO'S, AND OTHER ELECTRICAL DEVICES SHOWN SHALL BE RECESSED MOUNTED INTO A WALL, FLOOR OR CEILING UNLESS SPECIFICALLY NOTED OTHERWISE.
- 17) ALL RECEPTACLES (EXCEPT SPECIFIED HUBBLE PIN AND SLEEVE) SHALL BE FURNISHED BY THE E.C. THE RECEPTACLES INCLUDING PIN AND SLEEVE TYPE SHALL BE INSTALLED BY THE EC.
- 18) EC SHALL PROVIDE AND INSTALL STAINLESS COVER PLATES ON ALL RECEPTACLES AND J-BOXES. ADDITIONALLY, EC SHALL PROVIDE AND INSTALL ORANGE NYLON COVER PLATES MARKED "COMPUTER ONLY" ON ALL ISOLATED GROUND/DEDICATED RECEPTACLES.
- 19) POWER AND CONTROL CORDS ARE FURNISHED WITH KITCHEN APPLIANCES. THE EC SHALL CONNECT CORD SETS TO APPLIANCES AS REQUIRED.
- 20) MOST KITCHEN REMODELS WILL REQUIRE SOME LEVEL OF CEILING REPAIR. THIS WILL BE THE RESPONIBILITY OF THE GC.
- 21) ALL HOLES IN FRONT COUNTER FOR POS CORDS AND CABLES SHALL BE LOCATED BY OWNER AND DRILLED
- 22) EC SHALL PROVIDE A DUPLEX RECEPTACLE AND LOW VOLTAGE BROADBAND CONNECTION FOR THE INSTALLATION OF PLASMA TELEVISIONS. COORDINATE EXACT LOCATIONS WITH PM & DECOR COMPANY. FOR BROADBAND CONNECTION, EC SHALL PROVIDE A 4 X 4 BOX WITH A 3/4" CONDUIT STUB-UP WITH A BUSHING INTO ACCESSIBLE CEILING SPACE.
- 23) WHERE PIPING IS LOCATED WITHIN WALL CAVITIES, ACCESS TO THE CLEANOUTS SHALL BE PROVIDED.
- 24) DIMENSIONS SHOWING THE LOCATION OF DRAINS AND FLOOR SINKS ARE CENTERLINE DIMENSIONS.
- 25) GAS PIPING SHALL NOT PENETRATE ANY FIRE-RATED CHASE, SHAFT, DUCTWORK OR PLENUM.
- 26) GC TO RE-BALANCE THE HVAC SYSTEM AFTER ANY EXHAUST HOOD HAS BEEN REPLACED OR RELOCATED. 27) ALL EQUIPMENT SHALL BE INSTALLED IN ACCORDANCE WITH ITS LISTING AND/OR THE MANUFACTURER'S
- INSTALLATION INSTRUCTIONS. 28) UPON COMPLETION OF INSTALLATION, THE GAS PIPING SYSTEM SHALL BE PURGED OF DELETERIOUS MATERIAL AND SHALL BE PRESSURE TESTED. IF THE MINIMUM PRESSURES ARE NOT MET, THIS SHALL BE
- IMMEDIATELY REPORTED TO THE MCDONALD'S CONSTRUCTION MANAGER. 29) FLEXIBLE DUCTWORK SHALL NOT PENETRATE WALLS. SHEET METAL DUCTWORK IS REQUIRED AT ALL
- FIRE-RATED AND DRAFT STOP WALL PENETRATIONS. 30) all grease exhaust ductwork seams and joints shall be continuously welded water-tight on THE EXTERNAL SURFACE OF THE DUCT SYSTEM. ALL WELDING SHALL BE PERFORMED BY A CERTIFIED
- 31) IN THE EVENT OF ADDITIONAL FRYER CAPACITY, THE O/O MUST ENGAGE LICENSED MECHANICAL ENGINEER THE M/E WILL BE REQUIRED TO ASSESS THE EXISTING EXHAUST HOOD FAN TO ENSURE IT IS CAPABLE OF HIGHER AIRFLOW AT A POTENTIALLY HIGHER STATIC PRESSURE. CONSTRUCTION DRAWINGS WILL BE REQUIRED OF THE M/E FOR PERMITTING. AFTER INSTALLATION, A CERTIFIED TEST AND BALANCE COMPANY WILL BE REQUIRED TO AIR BALANCE THE NEW AND ANY AFFECTED ROOF-TOP HVAC EQUIPMENT DEEMED AS
- 32) ALL ROOF-TOP CONDENSING UNITS THAT DISCHARGE HORIZONTALLY SHALL BE ORIENTED SUCH THAT THE DISCHARGE DOES NOT BLOW IN THE DIRECTION OF AN OUTDOOR AIR INTAKE.
- 33) POS INSTALLER TO COORDINATE RELOCATION OF POS SYSTEM WITH O/O AND MCDONALDS CONSTRUCTION ALL CABLES FURNISHED AND INSTALLED BY POS SUPPLIER.
- 34) NEW POS(S) ARE SHOWN TO MEET NATIONAL BUILDING AND EQUIPMENT STANDARDS PER MCDONALD'S . FINAL LOCATION OF NEW POS(S) TO BE COORDINATED WITH O/O. POS INSTALLER TO COORDINATE LOCATION OF POS SYSTEM WITH O/O AND MCDONALDS CONSTRUCTION. ALL CABLES FURNISHED AND INSTALLED BY POS SUPPLIER.
- 35) PLUMBING FOR COMBI OVENS TO BE ROUTED TO FLOOR SINK DRAIN. GC TO VERIFY IF SINK HAS A GREASE INTERCEPT.

PART OF THE SCOPE OF WORK BY THE M/E.


SYMB	OL <b>LEGEND</b>	
$\bigcirc$	DUPLEX OUTLET (SB OR TL)	 FUTURE/OPTIONAL EQUIPMENT
	SINGLE OUTLET (SB OR TL)	 NEW EQUIPMENT ON EQUIPMENT PLAN
$\bigoplus$	QUAD OUTLET (SB OR TL) SPECIAL OUTLET (SEE SCHEDULE)	 RELOCATED EQUIPMENT ON EQUIPMENT PLAN
$\bigcirc$	J-BOX	 EXISTING EQUIPMENT
(5)	EXHAUST DUCT ABOVE HOOD	 EQUIPMENT ON ROUGH-IN PLAN
$\bigcirc$	EXHAUST DUCT ABOVE HOOD	 EXISTING TRUSSES
0	DATA CABLE	 SERVICE AREA
	SLEEVE	 NEW MENU BOARD VALANCE
9	REFRIGERATION LINES	EXISTING FULL WALL
0	WATER OR GAS LINE	 EXISTING LOW WALL
$\bigcirc$	CLEAN OUT	NEW FULL WALL
	FLOOR SINK	NEW LOW WALL
	FLOOR DRAIN	 DEMO WALL



H + K INTERNATIONAL

H + K DALLAS INC 2200 SKYLINE DR. MESQUITE, TX 75149 2 1 4 . 8 1 8 . 3 5 0 0

	DATE:	12SEP22		
2	DRAWN:	AR		
R	CHECKED:	EM		
	SCALE	SFF DI AN		

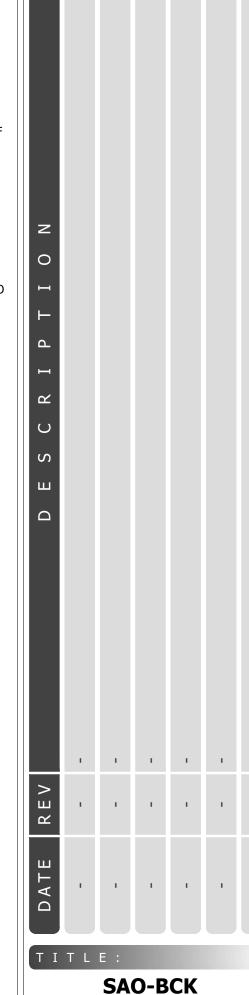

**EQUIPMENT LAYOUT 4215 RAINBOW BOULEVARD KANSAS CITY, KS** 

THESE DRAWINGS SPECIFICATIONS ARE THE PROPERTY OF H+K AND SHALL NOT BE REPRODUCED OR COPIED

McDONALD'S **CORPORATION** 

OAK BROOK, ILLINOIS S T O R E #:

04056

150043

1 OF 2 SHEET:

AS-BUILT CONDITIONS WERE TRANSFERRED FROM 3RD PARTY SURVEY AND ACCURACY SHOULD BE CONFIRMED BY GC AND/OR MCDONALD'S ACM PRIOR TO INSTALL

ТЕМ #	QTY	OPT	ITEM DESCRIPTION	MFGR	UNIT ID	UL LIST	NSF LIST	FURN BY	REMARKS
18	3	N	MODULAR FRONT COUNTER BASE	DÉCOR	MFC	-	2	GC	SIZE VARY PER MATRIX
19	1	N	MODULAR FRONT COUNTER DELIVERY POD	DÉCOR	-	-	2	GC	-
1.26	1	N	DELIVERY STAGING STAND - 30" X 36"	METRO	SEE ELEV	-	2	KES	STAINLESS STEEL TOP W/ 5 SHELVES
7.11	1	N	30" BASE REFRIGERATOR NEW SWITCHABLE	H&K	SEE ELEV	-	-	KES	-
7.93	1	N	MCFLURRY SHELF	H&K	SEE ELEV	-	2	KES	MOUNTS TO COMBO MACHINE
6.00	2	N	POS - VIDEO MONITOR	POS	POS	E106786	-	OWNER	GC/POS INSTALLER TO COORDINATE LOCATION W/ O/O
7.00	1	N	PARK/SERVE/ROTATE BUMP BAR	BY OWNER	BY OWNER	-	-	OWNER	GC/POS INSTALLER TO COORDINATE RELOCATION W/ O/O
9.00	2	N	POS - RECEIPT PRINTER	POS	POS	OEM	-	OWNER	SHELF REQUIRED FOR FRONT COUNTER APPLICATIONS
03.00	1	N	BASE REF. SHELF & DUAL POINT OAS @ C.I (WITH CUPS)	H&K	H&K #84150	-	-	KES	-
00.20	1	R	DESSERT BUTLER	-	-	-	-	OWNER	-
00.00	1	F	EXISTING OATMEAL	_	_	_	_	OWNER	_
04.12	3	R	RELOCATED DIGITAL MENUBOARD	-	_	_	-	OWNER	EQP. INSTLR. TO RELOCATE EQUIPMENT, GC TO RELO UTILITIES AS NEEDED
10.93	1	R	RELOCATED CUP LID HOLDER	_		_	_	OWNER	EQP. INSTLR. TO RELOCATE EQUIPMENT
21.01	1	R	RELOCATED COFFEE BREWER				_	OWNER	EQP. INSTLR. TO RELOCATE EQUIPMENT, GC TO RELO UTILITIES AS NEEDED
21.87	1	R	RELOCATED STANDOFF, COFFEE/SMOOTHIE STATIONS			_	_	OWNER	EQP. INSTLR. TO RELOCATE EQUIPMENT
23.05	1	R	RELOCATED COFFEE CREAM DISPENSER			_	_	OWNER	EQP. INSTLR. TO RELOCATE EQUIPMENT, GC TO RELO UTILITIES AS NEEDED
23.03 14.03	1	R	RELOCATED COPPEL CREAM DISPENSER  RELOCATED 5' CENTER ISLAND, BEV HEIGHT		_			OWNER	EQP. INSTER. TO RELOCATE EQUIPMENT, GC TO RELO UTILITIES AS NEEDED
3.02	1	R	RELOCATED S CENTER ISLAND, BEV TILIGITI  RELOCATED HEAT TREAT COMBINATION SHAKE/SUNDAE MACHINE	-				OWNER	EQP. INSTER. TO RELOCATE EQUIPMENT, GC TO RELO UTILITIES AS NEEDED
	1	R	RELOCATED FIGAT TREAT COMBINATION SHARL/SUNDAL MACHINE					OWNER	EQP. INSTER. TO RELOCATE EQUIPMENT, GC TO RELO UTILITIES AS NEEDED
05.11 07.00	1	R	RELOCATED FROZEN CARBONATED BEVERAGE  RELOCATED BLENDER - COUNTERTOP - MCFLURRY	-	+-	-	1-	OWNER	EQP. INSTER. TO RELOCATE EQUIPMENT, GC TO RELO UTILITIES AS NEEDED
)7.00 )7.90	1	R	RELOCATED BELINDER - COUNTERTOP - MCFEORRY  RELOCATED CUP TUBES FOR HEAT TREAT MACHINE	-	-	-	-	OWNER	EQP. INSTER. TO RELOCATE EQUIPMENT
	2			PV OWNED	POC.	OFM.	-		GC/POS INSTALLER TO COORDINATE RELOCATION W/ O/O
15.00	2	R	RELOCATED POS PC HARDWARE - FRONT COUNTER	BY OWNER	POS	OEM	-	OWNER	
6.00	1	R	RELOCATED OND MONITOR	POS	POS	E106786	-	OWNER	GC/POS INSTALLER TO COORDINATE RELOCATION W/ O/O
6.05		R	RELOCATED ORB MONITOR	BY OWNER	BY OWNER	-	-	OWNER	GC/POS INSTALLER TO COORDINATE RELOCATION W/ O/O
8.00	2	R	RELOCATED POS - CASH DRAWER	BY OWNER	BY OWNER	OEM	-	OWNER	GC/POS INSTALLER TO COORDINATE RELOCATION W/ O/O
9.00	2	R	RELOCATED POS - RECEIPT PRINTER	POS	POS	OEM	-	OWNER	GC/POS INSTALLER TO COORDINATE RELOCATION W/ O/O
9.10	1	E	EXISTING UTILITY CHASE F/ DRIVE THRU CBB	-	-	-	-	OWNER	-
0.12	1	E	EXISTING LID HOLDER 4" HIGH	-	-	-	-	OWNER	-
10.93	1	E	EXISTING CUP LID HOLDER	-	-	-	-	OWNER	-
20.00	1	E	EXISTING AUTOMATED BEVERAGE SYSTEM	-	-	-	-	OWNER	-
21.01	1	E	EXISTING COFFEE BREWER	-	-	-	-	OWNER	-
21.10	1	E	EXISTING SPECIALTY COFFEE	-	-	-	-	OWNER	-
21.11	1	E	EXISTING BLENDED ICE MACHINE	-	-	-	-	OWNER	-
21.90	1	E	EXISTING BRACKET FOR BUMP BAR & PRINTER	-	-	-	-	OWNER	-
23.05	1	E	EXISTING COFFEE CREAM DISPENSER	-	-	-	-	OWNER	-
24.01	1	E	EXISTING ORANGE JUICE DISPENSER	-	-	-	-	OWNER	-
25.01	3	E	EXISTING ICED BEVERAGE DISPENSER	-	-	-	-	OWNER	-
39.15	1	E	EXISTING ICE MACHINE - 1000 LB.	-	-	-	-	OWNER	-
43.15	2	E	EXISTING HEATED LANDING ZONE	-	-	-	-	OWNER	-
44.13	1	E	EXISTING CENTER ISLAND- 48" HLZ HEIGHT	-	-	-	-	OWNER	-
45.11	1	E	EXISTING BEVERAGE CABINET - DRIVE-THRU - 63" WIDE	-	-	-	-	OWNER	-
45.12	1	E	EXISTING BEVERAGE CABINET - DRIVE-THRU - 30 1/2" WIDE (CBB)	-	-	-	-	OWNER	-
946.00	1	Ε	EXISTING CUP DISPENSER VERTICAL F/ 3 TUBES	-	-	-	-	OWNER	-
51.03	2	E	EXISTING CUP LID HOLDER-SINGLE WIDE, 8" HIGH	-	-	-	-	OWNER	-
61.00	1	Ε	EXISTING FRY BAGGING STATION	-	-	-	-	OWNER	-
65.36	1	E	EXISTING 3-VAT FRYER - GAS - F/F/F	-	-	-	-	OWNER	-
73.01	1	E	EXISTING UNIVERSAL EXHAUST HOOD (R.H.) GAS 3-VAT FRYER	-	-	-	-	OWNER	-
00.08	1	E	EXISTING MECHANICAL CHASE, 9"x18" SGCL.	-	-	-	-	OWNER	-
081.01	1	Е	EXISTING PRODUCT LANDING SHELF - SOLID TOP	-	-	-	-	OWNER	-
59.03	1	Е	EXISTING CART	-	-	-	-	OWNER	-
79.03	1	Е	EXISTING REFRIGERATOR - UNDERCOUNTER	-	-	-	-	OWNER	-
79.96	1	E	EXISTING REFRIGERATOR - 36" WALL HUNG OR STAND MOUNTED	-	-	-	-	OWNER	-
81.01	1	E	EXISTING SPECIALTY COFFEE REFRIGERATOR-27" WIDE	-	-	-	-	OWNER	-
01.16	1	E	EXISTING WORK TABLE F/ ABS & CONDIMENTS	-	-	-	-	OWNER	-
15.98	2	E	EXISTING POS PC HARDWARE - D/T	-	-	-	-	OWNER	-
16.00	6	E	EXISTING POS - VIDEO MONITOR	-	-	-	-	OWNER	-
16.50	1	E	EXISTING DOG HOUSE, POS REGISTER	-	-	-	-	OWNER	-
17.00	1	E	EXISTING PARK/SERVE/ROTATE BUMP BAR	-	-	-	-	OWNER	-
218.00	1	E	EXISTING POS - CASH DRAWER	-	-	-	-	OWNER	-
19.02	1	E	EXISTING FOS - RECEIPT PRINTER	-		-	_	OWNER	-
237.00	1	E	EXISTING FOS - RECEIPT FRINTER  EXISTING PIE DISPLAY	<u> </u>			1_	OWNER	
	1 4	L	EXISTING PIE DISPLAT  EXISTING HAND SINK	-			1	OWNER	


		ELECTRICAL SCHEDULE										
	ITEM #	QTY	ITEM DESCRIPTION	VOLT PHASE	FLA DRAW	HP	RECEP TYPE	BRKR SIZE	COND WS	PNL CKT	HGT AFF	REQUIREMENTS
	207.11 E2	1	BASE REFRIGERATOR	120/1	3.2	Ţ-	5-20R	20A	1/2"C-2#12	DETERMINE IN FIELD	SEE RMKS	EC TO BRING POWER DOWN CHASE AND CONNECT TO CHASE MOUNTED RECEPTACLE
	211.00 E6	1	DELIVERY TABLET	120/1	3.0		(2) 5-20R	20A	1/2"C-2#12	DETERMINE IN FIELD	5'-6"	
	216.00 E11	2	POS - VIDEO MONITOR	120/1 ISOLATED	1.5 EA.	-	IG4700	20A	1/2"C-2#12IG	DETERMINE IN FIELD	5'-6"	EC TO PROVIDE/INSTALL RECEPTACLE, POS INSTALLER TO CONNECT POS
	216.00 E12	2	POS - VIDEO MONITOR	DATA CABLE	-	-	4x4x4 PB	-	-	-	5'-6"	EXTEND 2" CONDUIT ABOVE CEILING. CABLE FURNISHED AND INSTALLED BY POS SYSTEM SUPPLIER
	217.00 E1	1	PARK/ROTATE/SERVE BUMP BAR	DATA CABLE	-	-	-	-	-	EXISTING/RELOCATED	SEE RMKS	POS TO COORD W/ MCD O/O, RELOCATE EXIST. AS REQUIRED.
	219.00 E7	2	POS - RECEIPT PRINTER	120/1 ISOLATED	0.7		IG4710	20A	1/2"C-2#12IG	DETERMINE IN FIELD	SEE RMKS	PLUGS INTO CHASE OR SURFACE MOUNT RECEPTACLE IG4710
	219.00 E8	2	POS - RECEIPT PRINTER	DATA CABLE	-	-	-	-	-	-	SEE RMKS	CABLE FURNISHED AND INSTALLED BY POS SYSTEM SUPPLIER
	8021.01 E3	1	RELOCATED COFFEE BREWER	VERIFY	VERIFY DRAW	VERIFY	VERIFY	20A SEE RMKS	VERIFY	DETERMINE IN FIELD	SEE RMKS	EC TO BRING POWER DOWN WALL, PROVIDE/INSTALL RECEPTACLE
	8023.05 E3	1	RELOCATED CREAM DISPENSER	VERIFY	VERIFY DRAW	VERIFY	VERIFY	VERIFY BREAKER	VERIFY	DETERMINE IN FIELD	SEE ELEV	EC TO BRING POWER DOWN WALL, PROVIDE/INSTALL RECEPTACLE
	8203.02 E1	1	RELOCATED HEAT TREAT COMBINATION SHAKE/SUNDAE MACHINE	VERIFY	VERIFY DRAW	VERIFY	VERIFY	VERIFY BREAKER	VERIFY	DETERMINE IN FIELD	SEE RMKS	EC TO BRING POWER DOWN WALL, PROVIDE/INSTALL RECEPTACLE
FEDED	8205.11 E1	1	FROZEN CARBONATED BEVERAGE	VERIFY	VERIFY DRAW	VERIFY	VERIFY	VERIFY BREAKER	VERIFY	DETERMINE IN FIELD	SEE RMKS	BEV INSTALLER TO DETERMIN/SUPPLY/INSTALL ELEC CONVERTER AS REQUIRED
	8207.00 E1	1	RELOCATED BLENDER - MCFLURRY - COUNTERTOP	VERIFY	VERIFY DRAW	VERIFY	VERIFY	VERIFY BREAKER	VERIFY	DETERMINE IN FIELD	SEE RMKS	OUTLET FOR FOOT PEDAL - BLENDER PLUGS INTO FOOT PEDAL PLUG
FDFD	8216.00 E1	1	RELOCATED POS - VIDEO MONITOR	VERIFY	VERIFY DRAW	VERIFY	VERIFY	VERIFY BREAKER	VERIFY	DETERMINE IN FIELD	SEE ELEV	EC TO PROVIDE/INSTALL RECEPTACLE, POS INSTALLER TO CONNECT POS
	8216.00 E2	1	RELOCATED POS - VIDEO MONITOR	VERIFY	VERIFY DRAW	VERIFY	VERIFY	VERIFY BREAKER	VERIFY	DETERMINE IN FIELD		CABLE FURNISHED/INSTALLED BY POS INSTALLER
EEDED	PLUMBING SCHEDULE											
EEDED	ITEM #	QTY	ITEM DESCRIPTION GAS TYPE G	GAS BTU GAS SIZE	ZE HOT WATER	COLD W	WATER MIS	SC PLBG HGT AF	FF DRAIN	REQUIREMENTS		
EEDED	8021.01 P3	1	RELOCATED COFFEE BREWER		-	-		1" FILTERED   SEE RM	MKS -	DN WALL FROM REVERS	E OSMOSIS SY	STEM. BEV INSTALLER TO CONN CW LINE, PER LOCAL CODES
EEDED	8205.11 P1	1	RELOCATED FROZEN CARBONATED BEVERAGE		-	-	-	-	-	PC TO RELOCATE UTILIT	TIES AS NEEDE	



H + K INTERNATIONAL H + K DALLAS INC.

2200 SKYLINE DR. MESQUITE, TX 75149 2 1 4 . 8 1 8 . 3 5 0 0

D A T E : 12SEP22 DRAWN: AR CHECKED: EM S C A L E : SEE PLAN

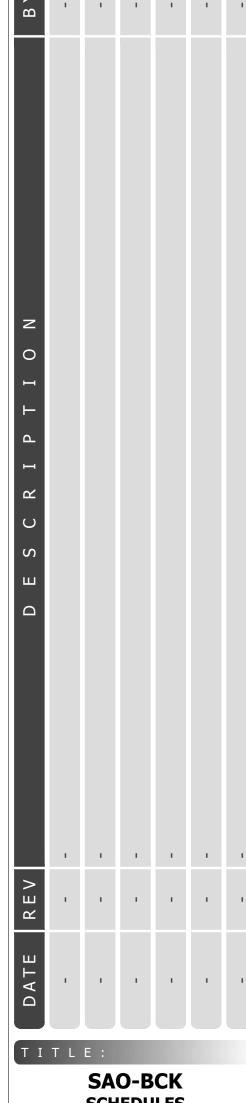

SCHEDULES

4215 RAINBOW BOULEVARD KANSAS CITY, KS


THESE DRAWINGS SPECIFICATIONS ARE THE PROPERTY OF H+K AND SHALL NOT BE REPRODUCED OR COPIED WITHOUT H+K'S WRITTEN PERMISSION CUSTOMER:

McDONALD'S CORPORATION

OAK BROOK, ILLINOIS STORE #:

150043 SHEET #

2 OF 2 SHEET:

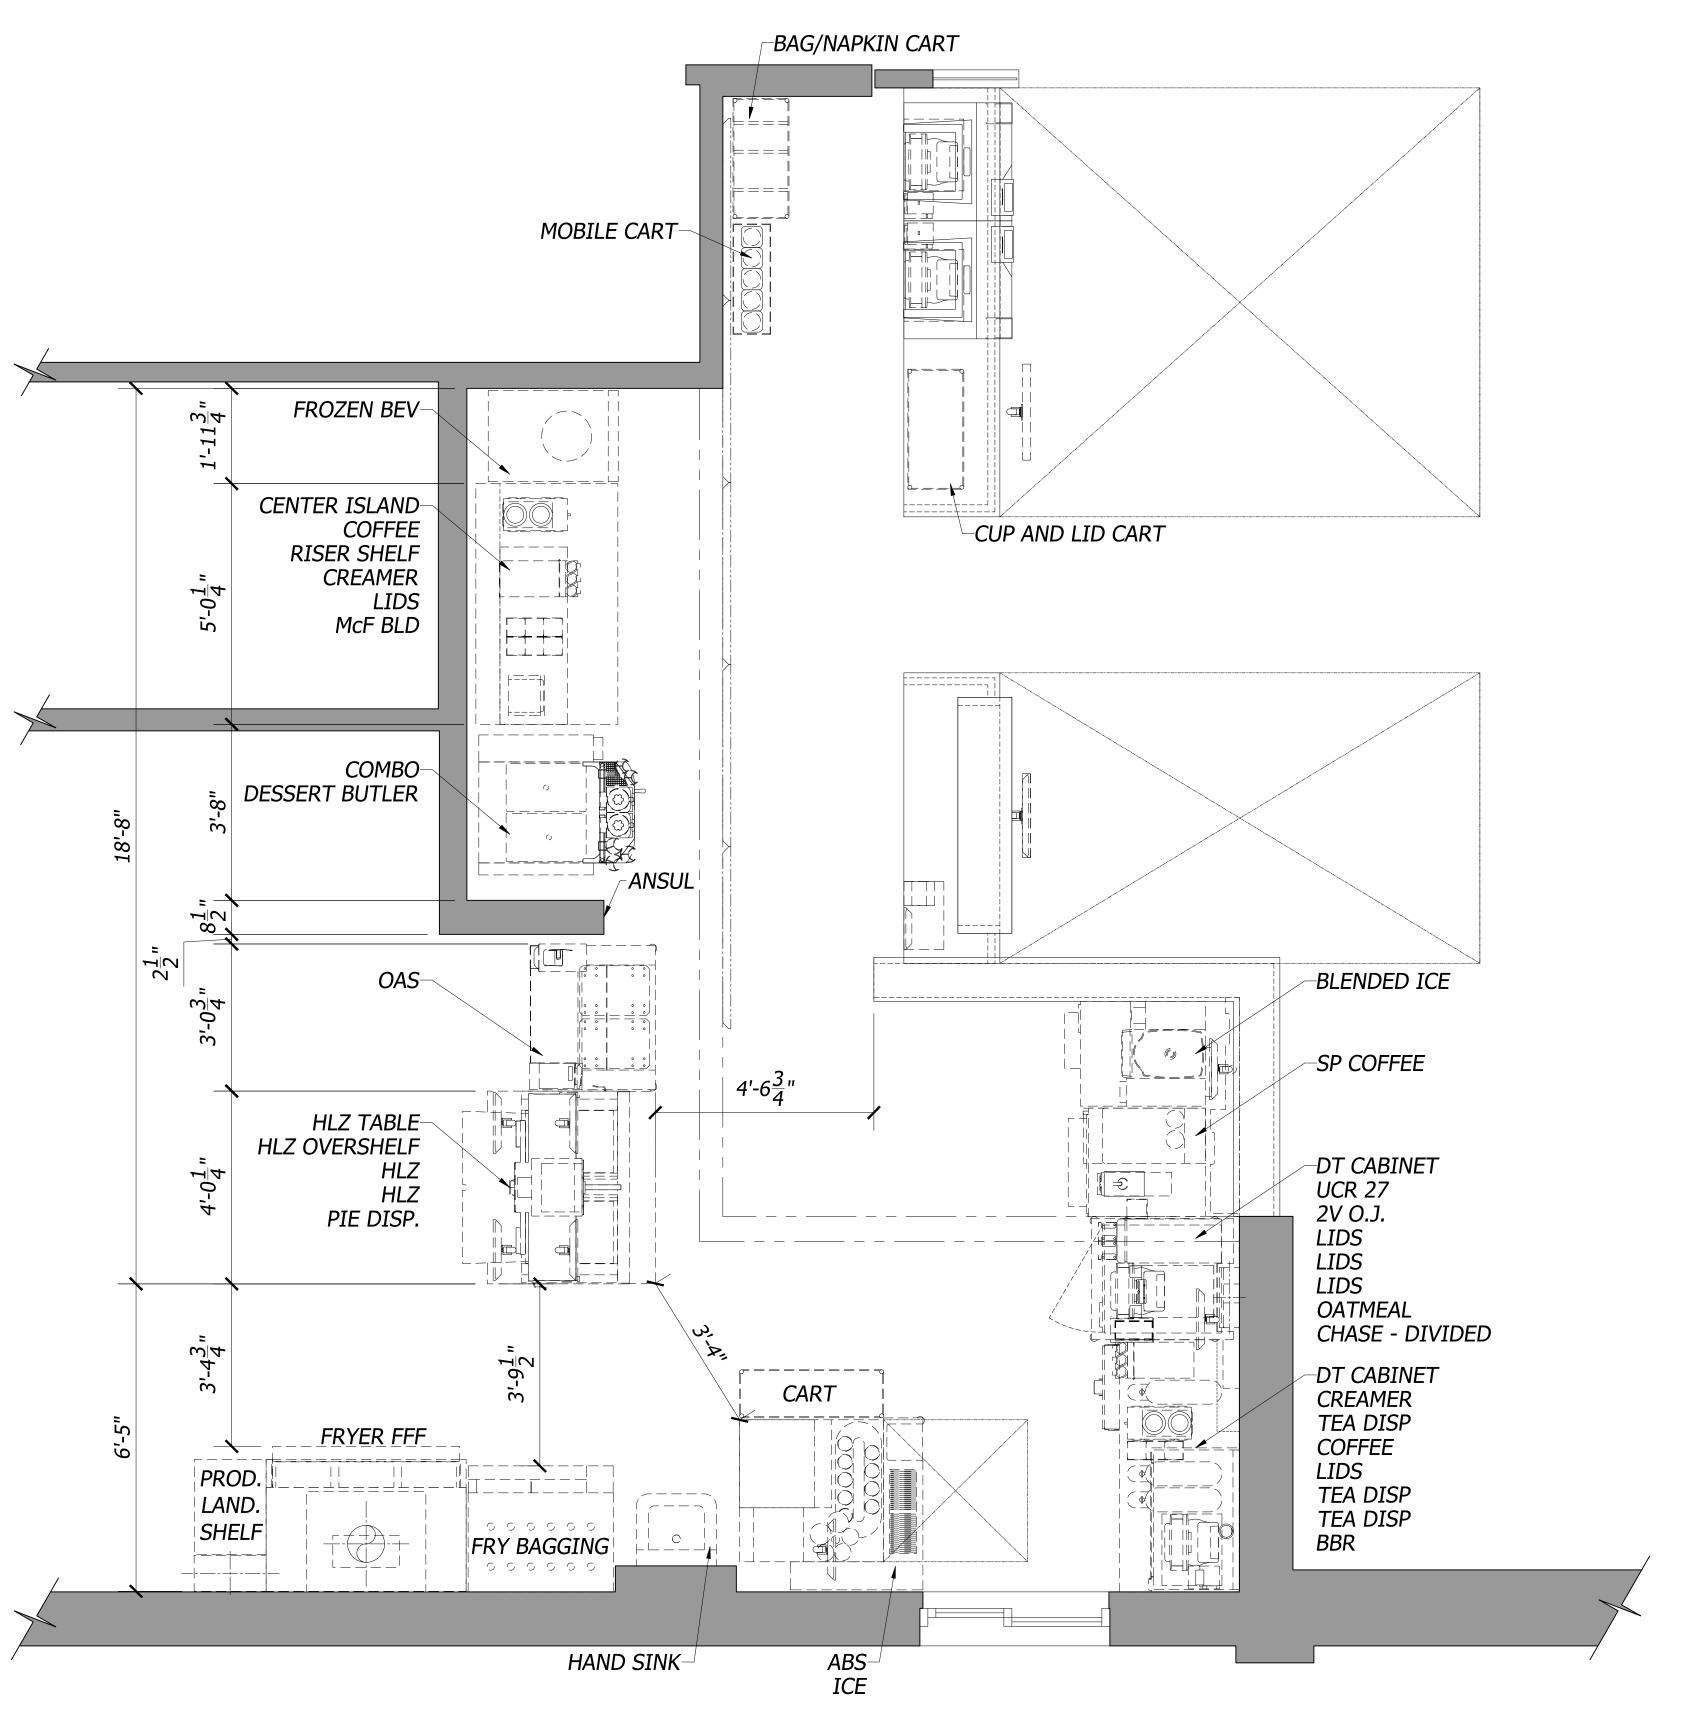

AS-BUILT PLAN

1/2"=1'-0"




H + K INTERNATIONAL H + K D A L L A S I N C. 2200 SKYLINE DR.

MESQUITE, TX 75149 2 1 4 . 8 1 8 . 3 5 0 0

DATE: 06SEP22

DRAWN: EC

CHECKED: AR

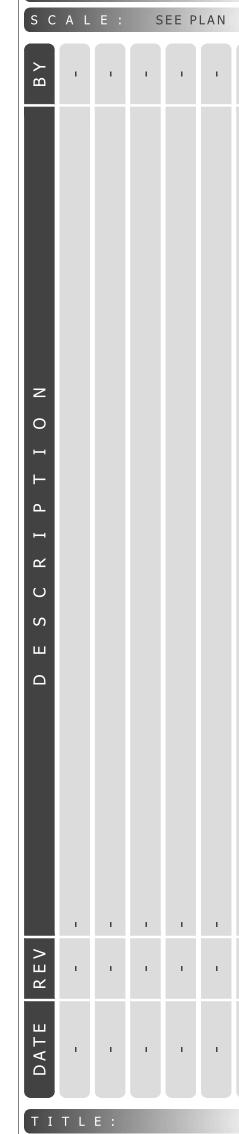

SAO-BCK AS-BUILT LAYOUT

4215 RAINBOW BOULEVARD KANSAS CITY, KS

THESE DRAWINGS SPECIFICATIONS ARE THE PROPERTY OF H+K AND SHALL NOT BE REPRODUCED OR COPIED WITHOUT H+K'S WRITTEN PERMISSION

## McDONALD'S CORPORATION

OAK BROOK, ILLINOIS

S T O R E # :

04056

150043

1 OF 1

LEGEND

EXISTING EQUIPMENT
EXISTING TRUSSES
SERVICE AREA
OVERHEAD

EXISTING FULL WALL EXISTING LOW WALL

AB-1

