


NOTE: FOOTCANDLE LEVELS SHOWN ON PLAN REFLECT ILLUMINATION FROM AMBIENT CEILING FIXTURES ONLY. CONTRIBUTION FROM DECORATIVE PENDANTS, CHANDELIERS, WALL SCONCES, OR TRACK LIGHTING NOT SHOWN.

NOTE: PENDANT LOCATIONS SHOWN ON PLAN ARE LOCATED BY SEATING AND DECOR COMPANY AND ARE SUBJECT TO CHANGE BASED ON FINAL SEATING LAYOUT. SPECIFIC DECORATIVE FIXTURE SELECTION BY SEATING AND DECOR COMPANY OR OWNER/OPERATOR.

NOTE: FIXTURE QUANTITIES AND LOCATIONS MAY VARY DEPENDING UPON FINAL REFLECTED CEILING PLAN/FURNITURE LAYOUT AS DETERMINED BY OTHERS.

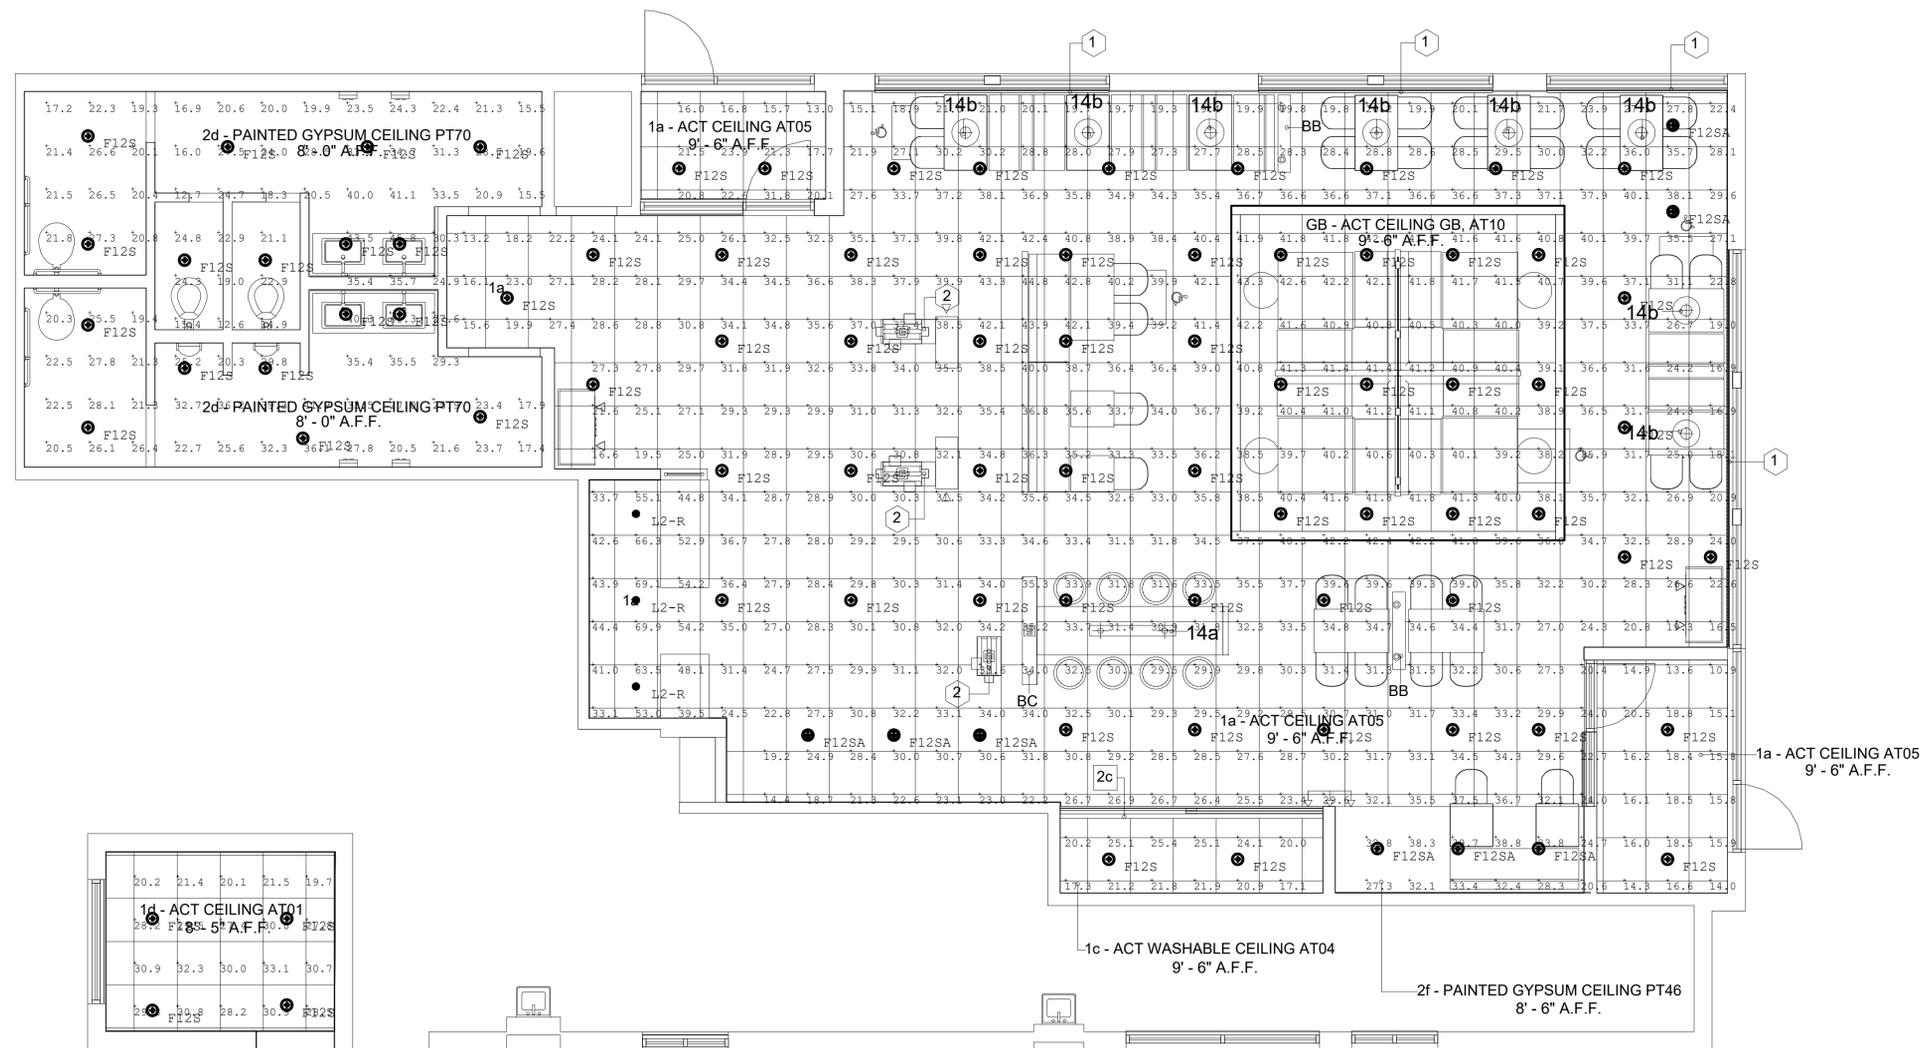

Luminaire Schedule				
Symbol	Qty	Label	Description	LLF
⊕	80	F12S	LB6LEDA10L30K9SA / DBXQL	0.900
⊕	8	F12SA	LB6LEDA10L30K9WW SA / DBXQL	0.900
⊕	3	L2-R	RDA-136LM-30-NF-S	0.900

Calculation Summary							
Label	CalcType	Units	Avg	Max	Min	Avg/Min	Max/Min
CREW Workplane	ILLUMINANCE	Fc	27.53	33.1	19.7	1.40	1.68
DINING Workplane	ILLUMINANCE	Fc	31.74	69.9	10.9	2.91	6.41
MENS Workplane	ILLUMINANCE	Fc	27.48	41.9	17.4	1.58	2.41
WOMENS Workplane	ILLUMINANCE	Fc	24.34	45.8	12.6	1.93	3.63

2100 Golf Road, Suite 460, Rolling Meadows, IL 60008
7800-544-4348

UNLESS OTHERWISE SPECIFIED, ALL DIMENSIONS ARE IN INCHES

SCALE 1/4" = 1' 0"

DRAWN BY VS

POINT-BY-POINT FOOTCANDLE PLOT FOR
MCDONALDS
3124 10 MILE RD
JEFFERSON CITY, MO

NATIONAL STORE NUMBER
5797

DATE 04/17/23 DRAWING NUMBER 48603

1. LUMINAIRE DATA IS TESTED TO INDUSTRY STANDARDS UNDER LABORATORY CONDITIONS. OPERATING VOLTAGE AND NORMAL MANUFACTURING TOLERANCES OF LAMP, BALLAST, AND LUMINAIRE MAY AFFECT FIELD RESULTS.

2. CONFORMANCE TO FACILITY CODE AND OTHER LOCAL REQUIREMENTS IS THE RESPONSIBILITY OF THE OWNER AND/OR THE OWNER'S REPRESENTATIVE.

3. THIS LAYOUT MAY NOT MEET TITLE 24 OR LOCAL ENERGY REQUIREMENTS. IF THIS LAYOUT NEEDS TO BE COMPLIANT WITH TITLE 24 OR OTHER ENERGY REQUIREMENTS, PLEASE CONSULT FACTORY WITH SPECIFIC DETAILS REGARDING PROJECT REQUIREMENTS SO THAT REVISIONS MAY BE MADE TO THE DRAWING.