

VICINITY MAP



AERIAL IMAGE



STORE FRONT

McDonald's
NATIONAL STORE NUMBER: 05797
3124 S TEN MILE DR
JEFFERSON CITY, MO 65109

SHEET INDEX

SHEET	SHEET NAME
V0.00	COVER SHEET
V2.00	EXISTING FLOOR PLAN
V3.00	EXISTING REFLECTED CEILING PLAN
V4.00	EXISTING KITCHEN EQUIPMENT PLAN
V5.10	EXISTING INTERIOR ELEVATIONS
5	TOTAL SHEETS



19120 SE 34TH STREET
 SUITE 115
 VANCOUVER, WA 98683
 PROJECT CONTACT: MARTY LAKEY
 PHONE: 360.719.1952
 EMAIL: MLAKAY@PMDINC.COM


KEN MCCRACKEN, ARCHITECT

ABBREVIATIONS

A.F.F.	ABOVE FINISH FLOOR
ACT	ACOUSTICAL CEILING TILE
B.O.	BOTTOM OF
BOH	BACK OF HOUSE
CLG	CEILING
CONC	CONCRETE
GYP. BD.	GYP SUM BOARD
GLULAM	GLUE LAMINATED
MTL	METAL
O.W.	OPEN WEB
R/A	RETURN AIR
S/A	SUPPLY AIR
STL	STEEL
WD	WOOD
W.F.	WIDE FLANGE



ANNOTATION SYMBOL LEGEND

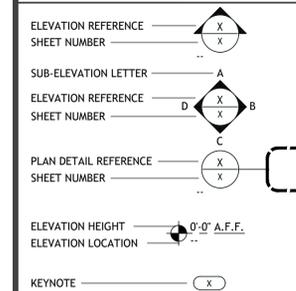

NOTE:
 HATCHING
 INDICATES AREA
 NOT INCLUDED IN
 SCOPE.

McDONALD'S
 NATIONAL STORE NUMBER: 05797
 3124 S TEN MILE DR
 JEFFERSON CITY, MO 65109


REV	DATE	DESCRIPTION
△	04.19.21	SURVEY PACKAGE

DRAWN BY: _____ TM
 CHECKED BY: _____ ML
 ARCH. PROJECT NO.:
 SV-MCD21022
 SHEET NAME:

COVER SHEET
 SHEET NUMBER:
V0.00

SYMBOL	DESCRIPTION	SYMBOL	DESCRIPTION
	RECESSED CAN LIGHT		MECHANICAL SUPPLY DIFFUSERS
	AIMABLE RECESSED CAN LIGHT		MECHANICAL RETURN AIR GRILLE
	STRIP LIGHT		EXHAUST FAN W/ LIGHT
	PENDANT / CHAIN HUNG LIGHT		CEILING FAN
	TRACK LIGHTING		ACCESS PANEL
	RECESSED TROFFER		ACCOUSTICAL CEILING TILE
	WALL MOUNTED SCONCE		GYPSUM BOARD
	RECESSED MULTI-HEAD		
	EXIT LIGHT		
	EMERGENCY LIGHT		
	PENDANT SECURITY CAMERA		
	SPEAKER		
	SPRINKLER		

CEILING PLAN SYMBOL LEGEND 4

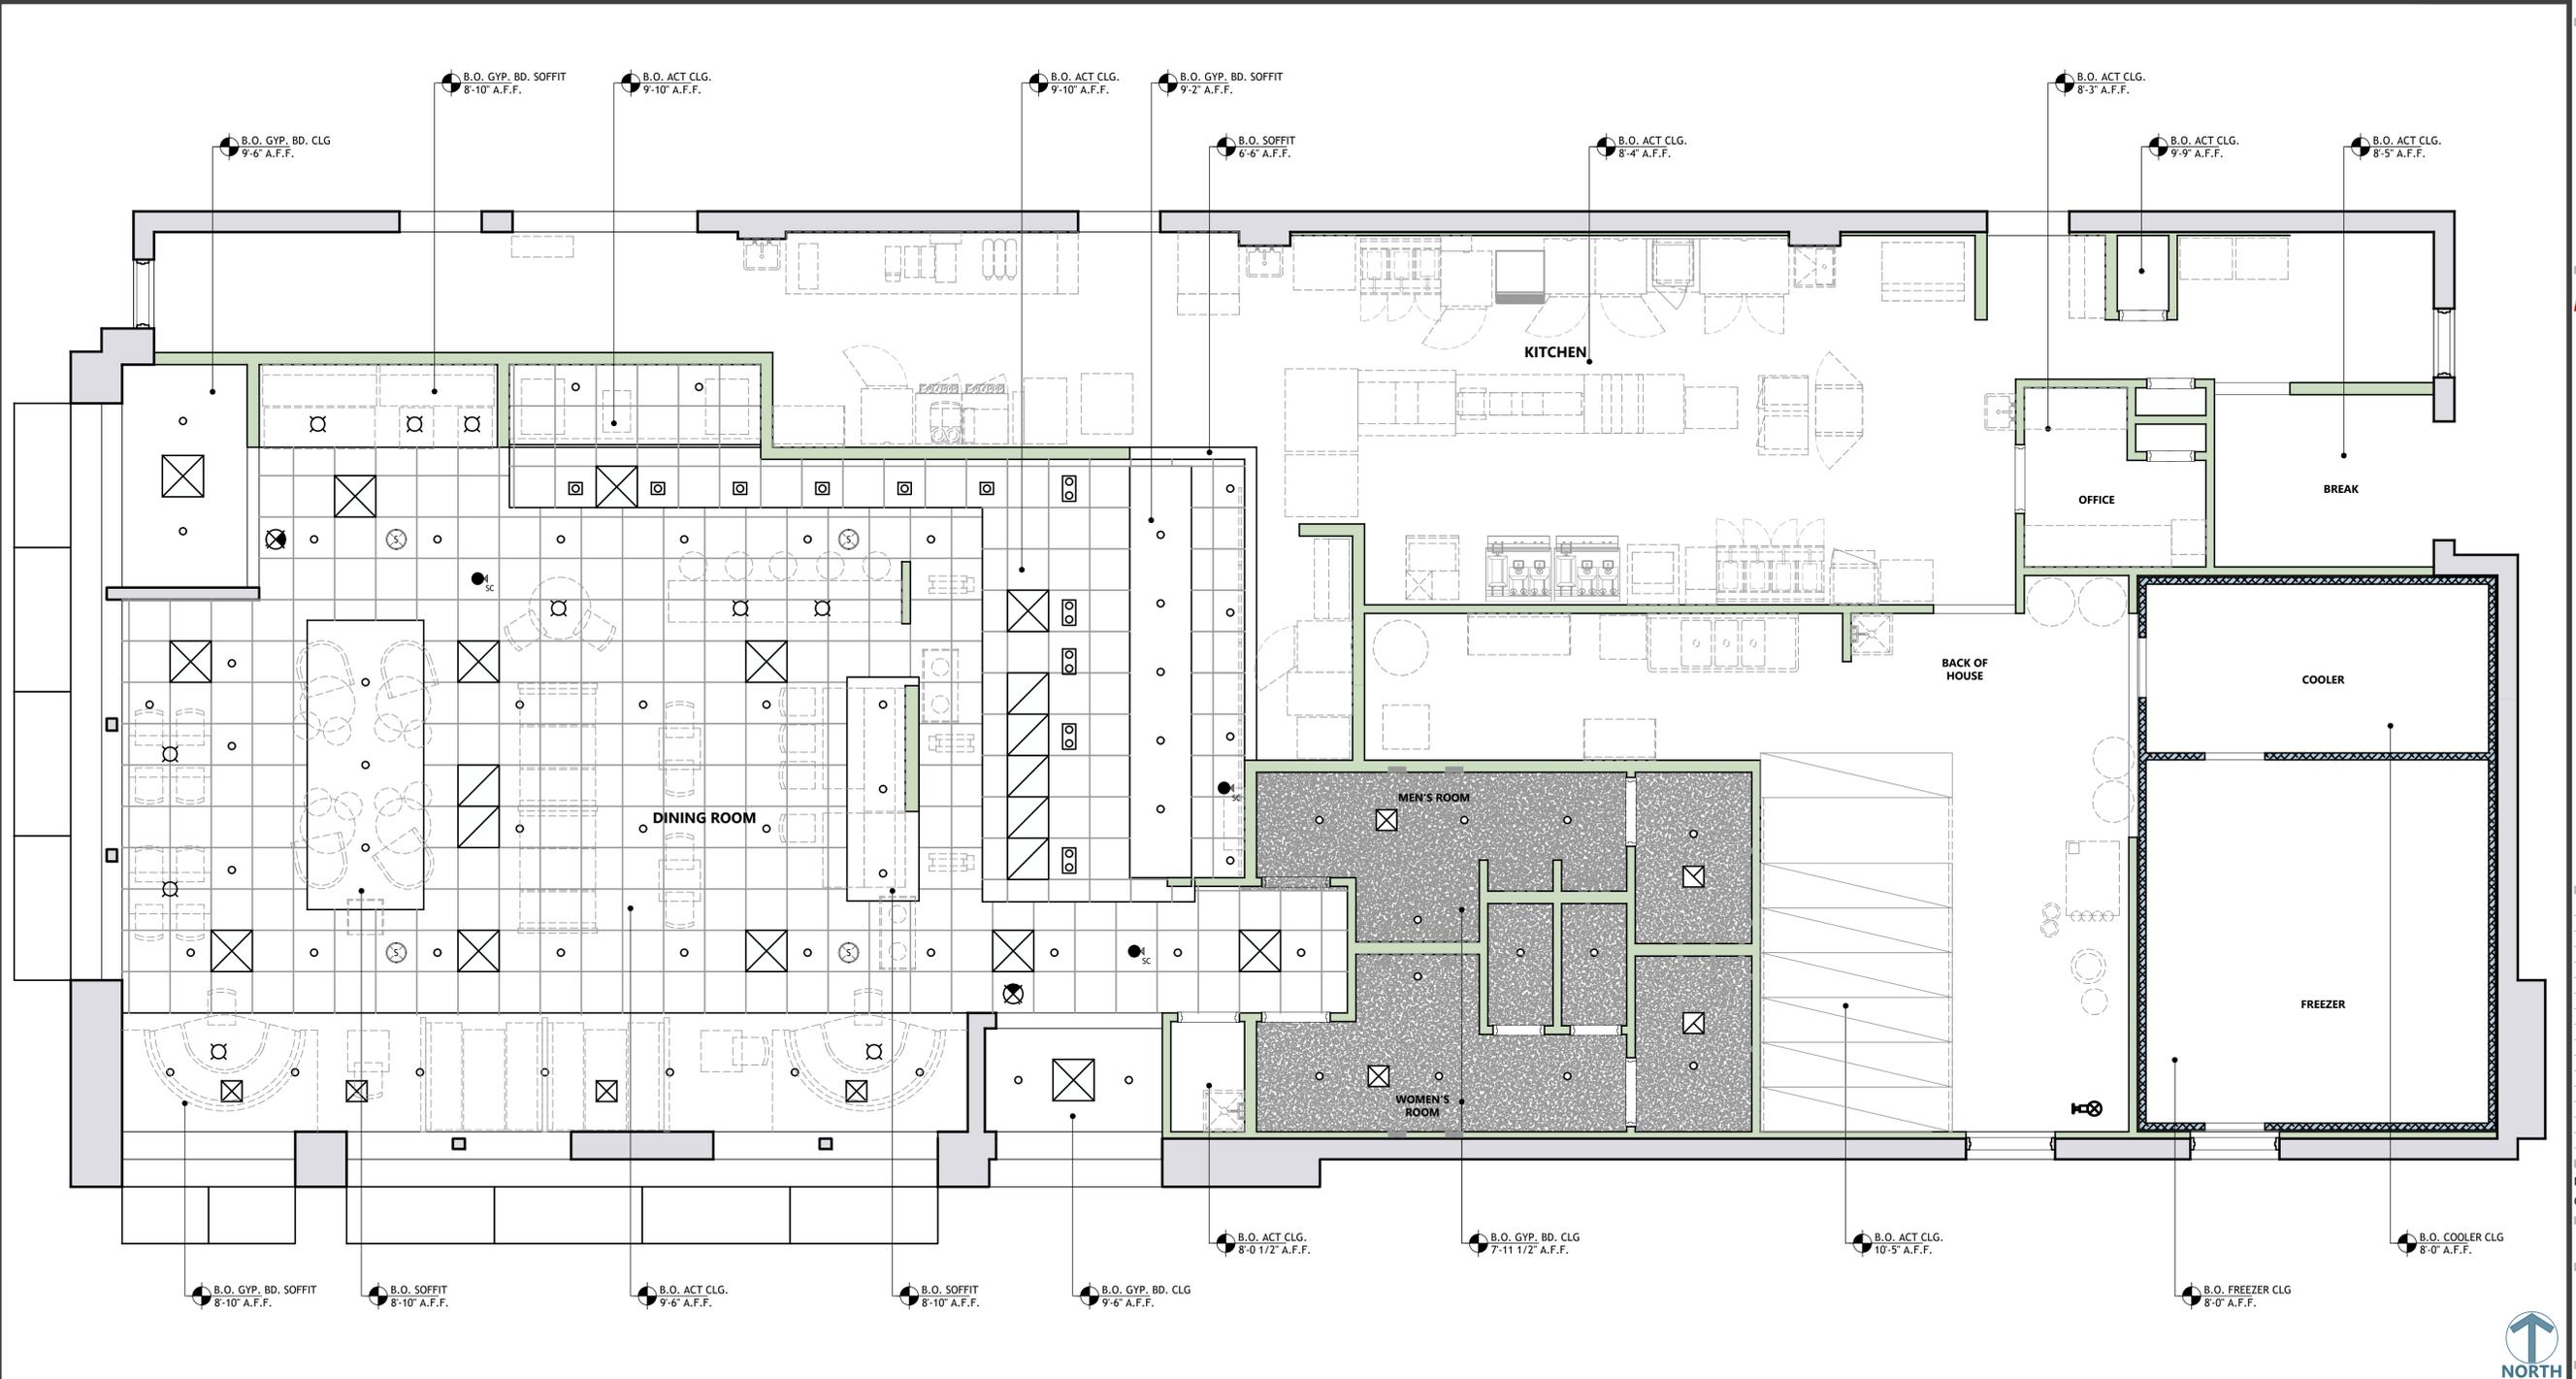

McDonald's
NATIONAL STORE NUMBER: 05797
3124 S TEN MILE DR
JEFFERSON CITY, MO 65109

REV	DATE	DESCRIPTION
△	04.19.21	SURVEY PACKAGE

DRAWN BY: _____ TM
CHECKED BY: _____ ML
ARCH. PROJECT NO.:
SV-MCD21022
SHEET NAME:
EXISTING CEILING PLAN
SHEET NUMBER:



1/4" = 1'-0" 1



McDonald's
NATIONAL STORE NUMBER: 05797
3124 S TEN MILE DR
JEFFERSON CITY, MO 65109

REV	DATE	DESCRIPTION
△ 04.19.21		SURVEY PACKAGE

DRAWN BY: TM
CHECKED BY: ML

ARCH. PROJECT NO.:
SV-MCD21022

SHEET NAME:

EXISTING KITCHEN
EQUIPMENT PLAN

SHEET NUMBER:

V4.00

